


ENLARGED ELECTRIC ROOM PLAN  
SCALE: 1/4"=1'-0"

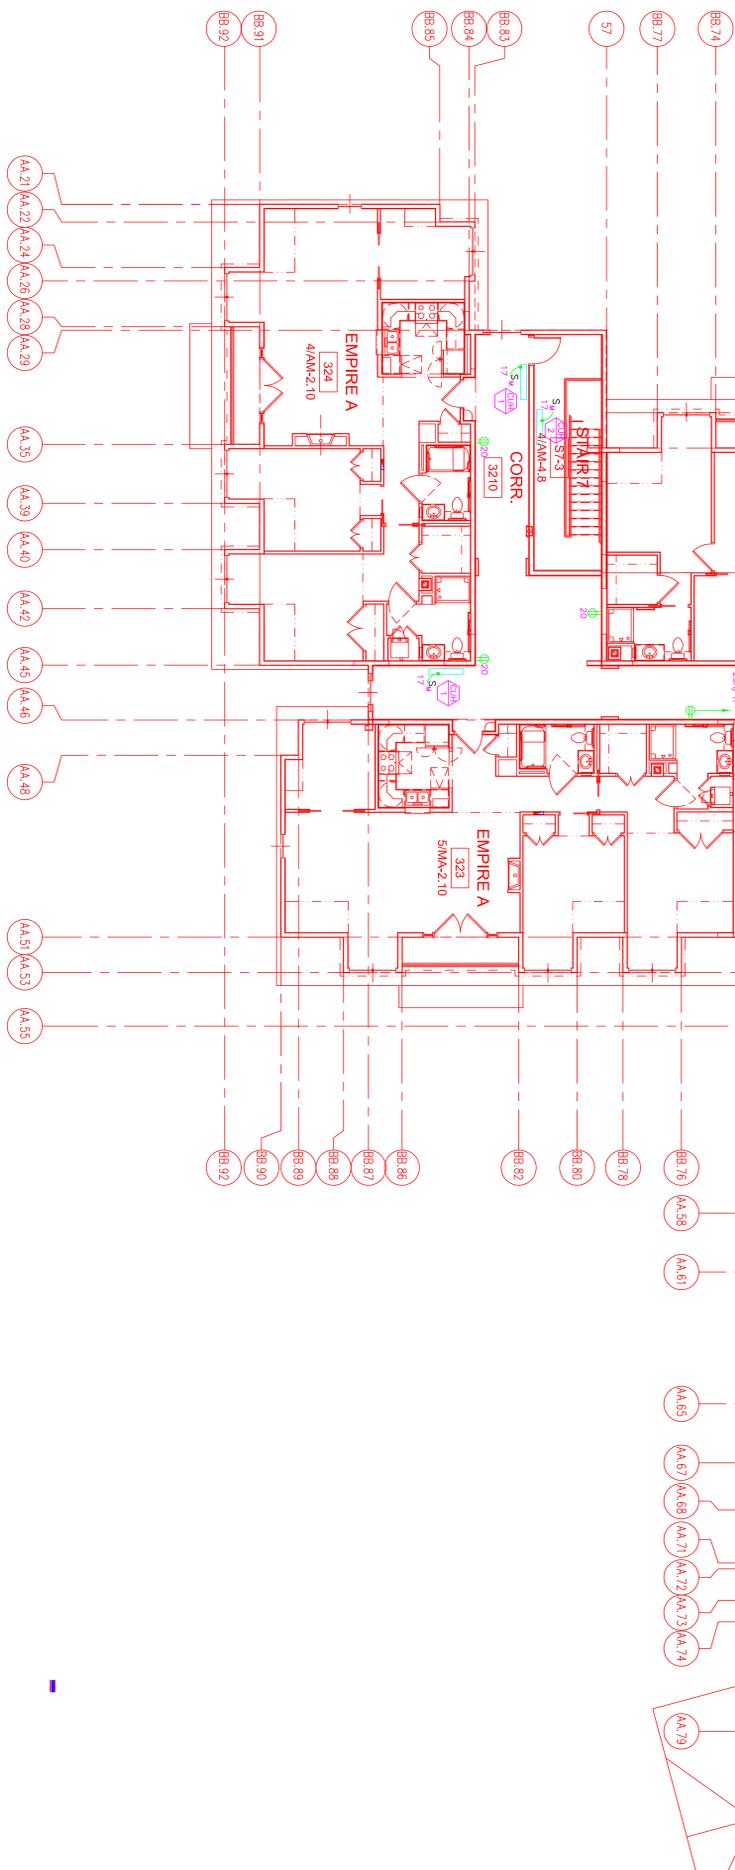

3RD FLOOR SECTION "A"  
SCALE: 1/8"=1'-0"

**EGEA**  
 ARCHITECTS  
 © 2007 EGA P.C.  
 12 Auburn Street, 01850  
 North Andover, MA  
 978-462-5515 Fax: 978-462-5555  
 528 Walnut Street  
 Chicopee, MA 01020  
 515-263-1800 Fax: 515-262-6880

- CIVIL ENGINEER - RIZZO ASSOCIATES, INC.
- STRUCTURAL ENGINEER - SHELLEY ENGINEERING, INC.
- MEP ENGINEER - BLW ENGINEERS, INC.
- INTERIOR DESIGNER - WELLESLEY DESIGN CONSULTANTS


# THE GROVES in LINCOLN

## CONGREGATE BUILDING

### LINCOLN, MA

Issued For:	Date:
Design Develop	7-20-07
50% CD Set	8-13-07
100% CD Set	10-17-07
100% S&I	11-19-08
Code Revisions	11-19-08
Fire Alarm Revs.	2-20-09
Lighting Revs.	3-10-10
Exit Sign Revs.	6-23-10

THIS MATERIAL IS CONFIDENTIAL AND MAY NOT BE DISCLOSED WITHOUT PRIOR WRITTEN CONSENT OF EGA P.C. COPYRIGHT 2007 EGA

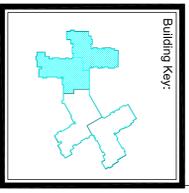

Sheet Title:  
**ELECTRICAL LEVEL THREE POWER PLAN**  
 Sheet Number:  
**EM-10.0**